


This design or drawing is the sole property of Calamba Water District. No part of this design or drawing may be reproduced or transmitted in any form or by any means without the written consent of its owner.

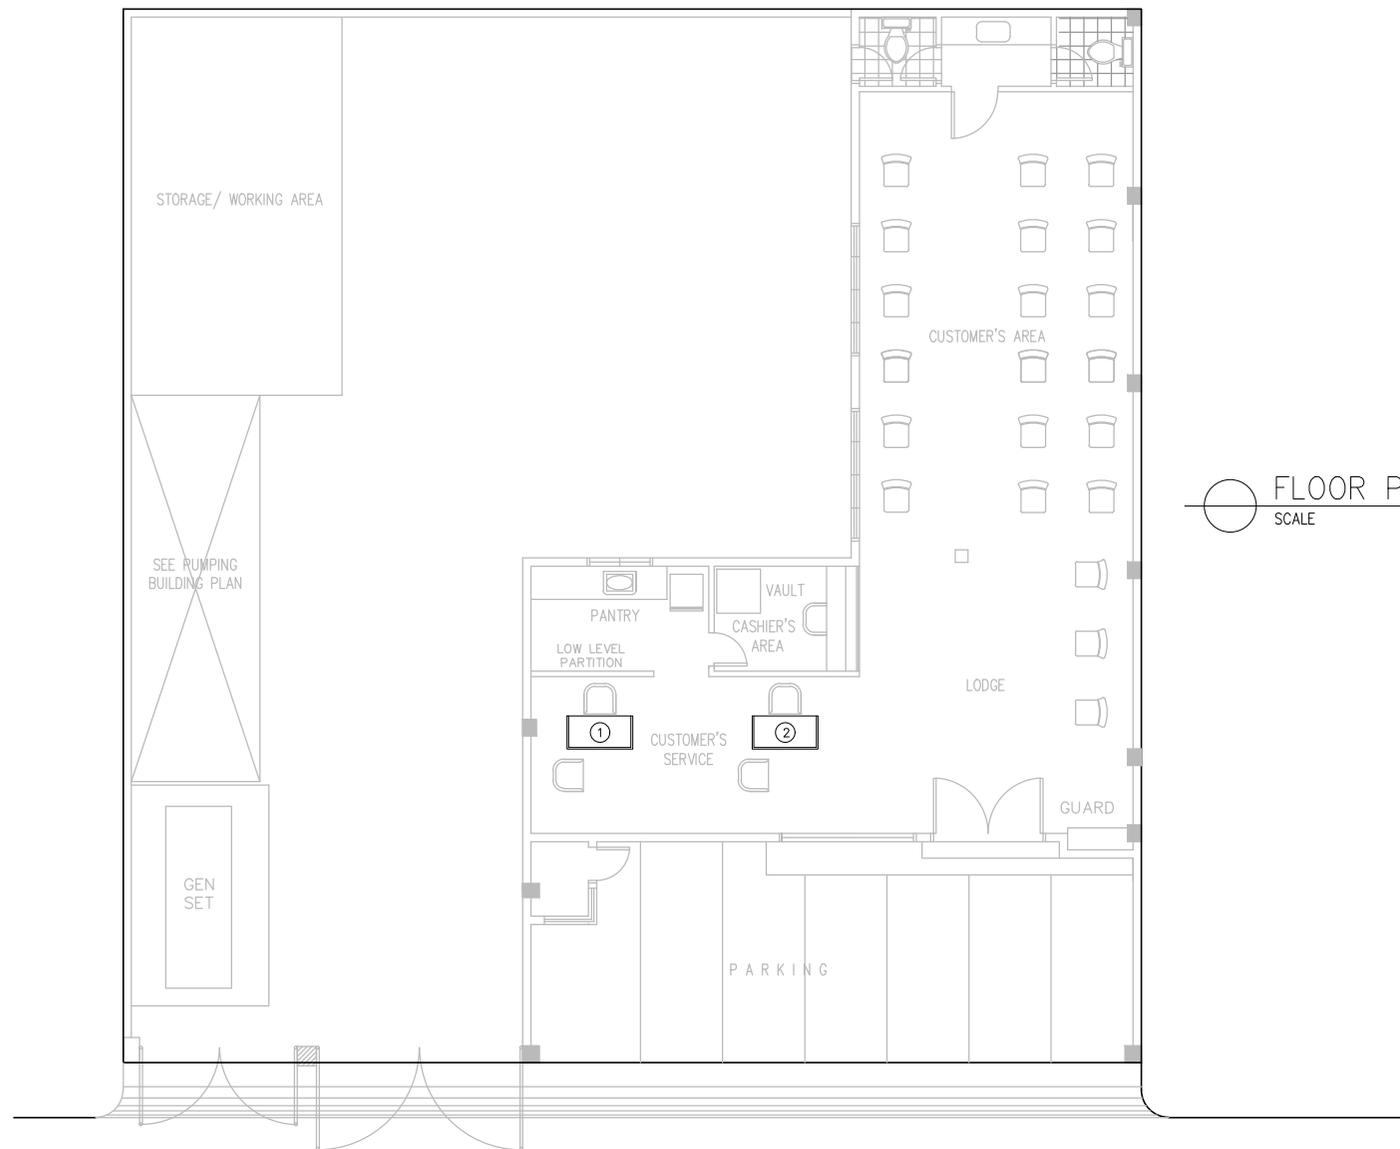

FLOOR PLAN
SCALE 1:125m.



CALAMBA WATER DISTRICT
ENGINEERING DEPARTMENT
PLANNING AND DESIGN DIVISION

24/7 Public Service
LAKEVIEW SUBD., HALANG, CALAMBA CITY

PROJECT TITLE:	MODULAR PARTITION
LOCATION:	NHA Office Brgy. Canlubang, Calamba City, Laguna

AUTOCAD BY:	ANGELO DEL PRADO
DESIGNED BY:	ANGELO DEL PRADO
CHECKED BY:	ENGR. R. CAPITILE
RECOMMENDED BY:	ENGR. J. GILLERA
APPROVED BY:	MR. E. A. AGUILAR JR.

SHEET CONTENTS:	AS DRAWN
-----------------	----------

DATE:	
SHEET NO.	1